



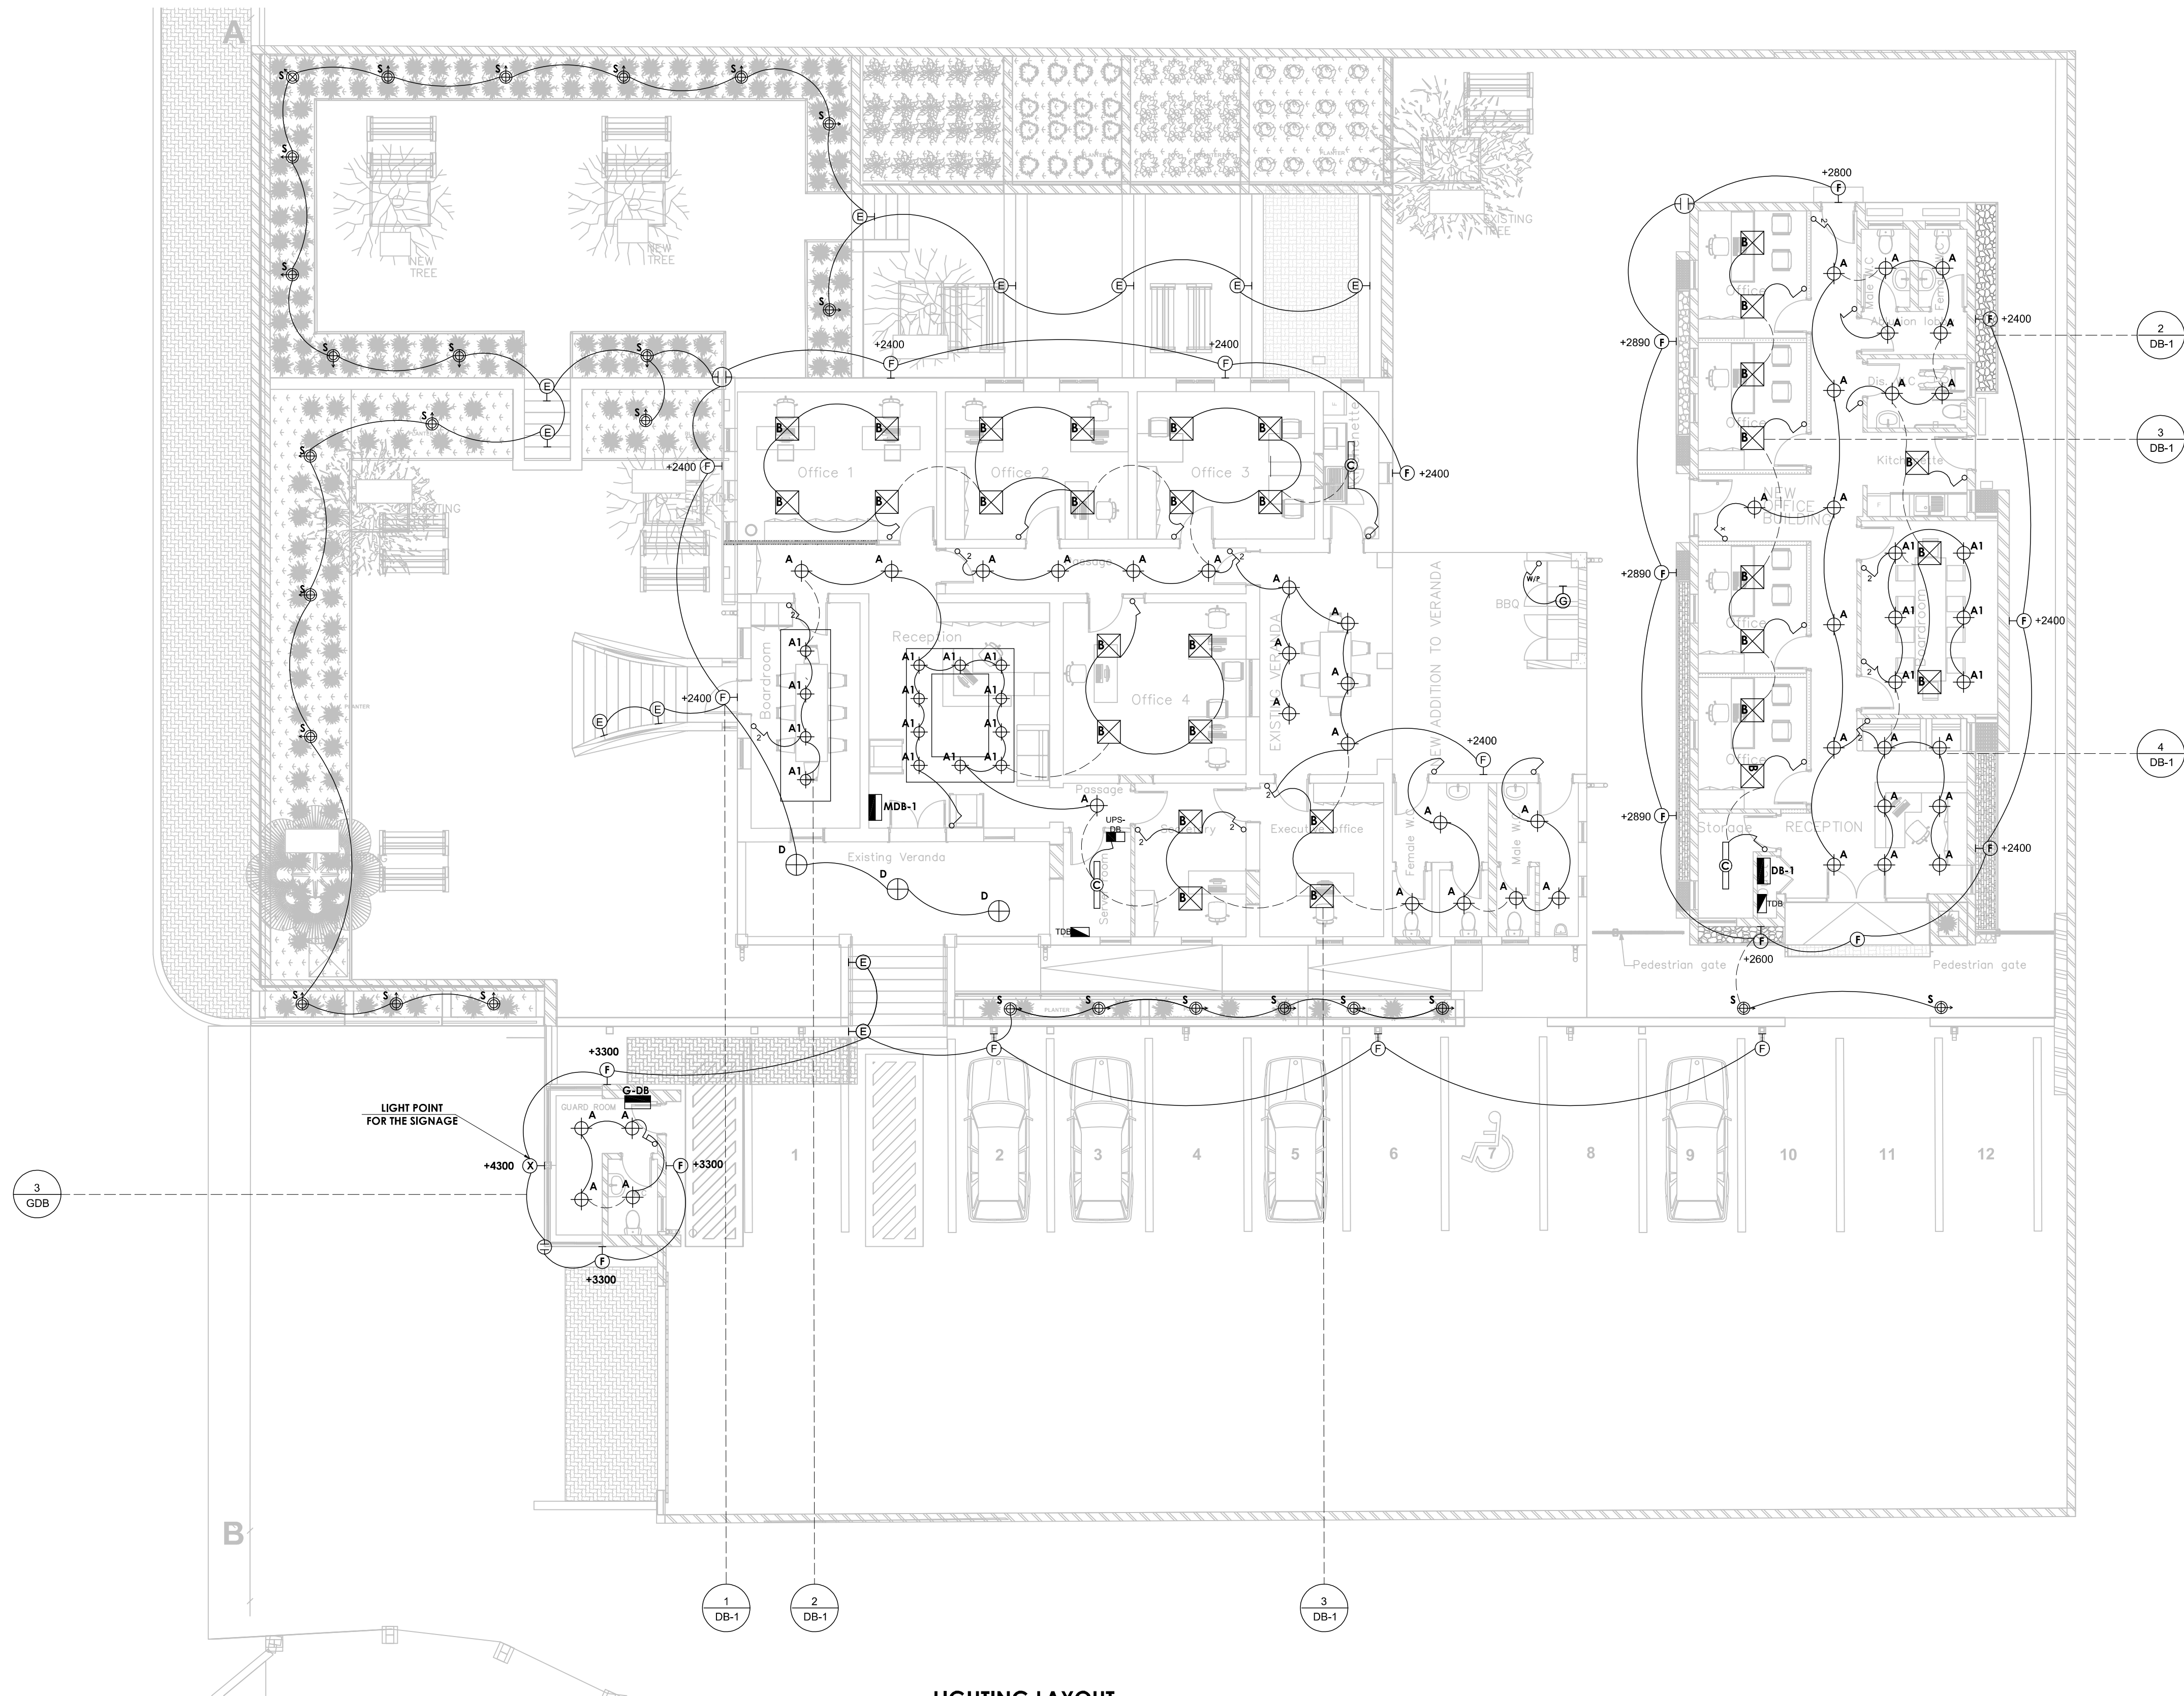

LIGHTING LAYOUT
SCALE 1:100

LIGHTING LEGEND:

SYMBOLS	DESCRIPTION	QTY
	ELECTRICAL DISTRIBUTION BOARD	
	RUBICON LIGHTING, AEGON LED DOWNLIGHT, 20W LED, 4000K, 2400 LUMENS (or equal & approved)	
	RUBICON LIGHTING, AEMELIA SURFACED MOUNTED LED DOWNLIGHT, 12W LED, 4000K, 900 LUMENS (or equal & approved)	
	RUBICON LIGHTING, THEIA 600x600mm LED PANEL, 30W LED, 4000K, NOT DIMMABLE (or equal & approved)	
	RUBICON, Phobos, 1236mm x 87mm x 60mm, 4000K, 81W, 6117lm	
	BRIGHT STAR LIGHTING, PEN42 RATTAN PENDANT, 60W LED	
	SPAZIO LIGHTING, RATIONAL, RECESSED LED FOOTLIGHT, 3000K, 2W, LED	
	RUBICON LIGHTING, SATURN, 1 x 24W, LED, BULKHEAD BLACK (or equal & approved)	
	SPAZIO LIGHTING, OZO-SLIM DOWN FACE 3CCT	
	RUBICON LIGHTING, SATURN, 1 x 24W, LED, BULKHEAD BLACK (or equal & approved)	
	ONE WAY, ONE LEVER SWITCH	
	TWO WAY, ONE LEVER SWITCH	
	INTERMEDIATE SWITCH	
	ONE WAY, TWO LEVER SWITCH	
	WEATHER PROOF ONE LEVER SWITCH	
	TWO WAY, TWO LEVER SWITCH	
	P9000 CABLE MANAGEMENT CHANNEL	
	200mm WIDE WELDED WIRE MESHED CABLE TRAY FOR ELECTRONIC CABLES	

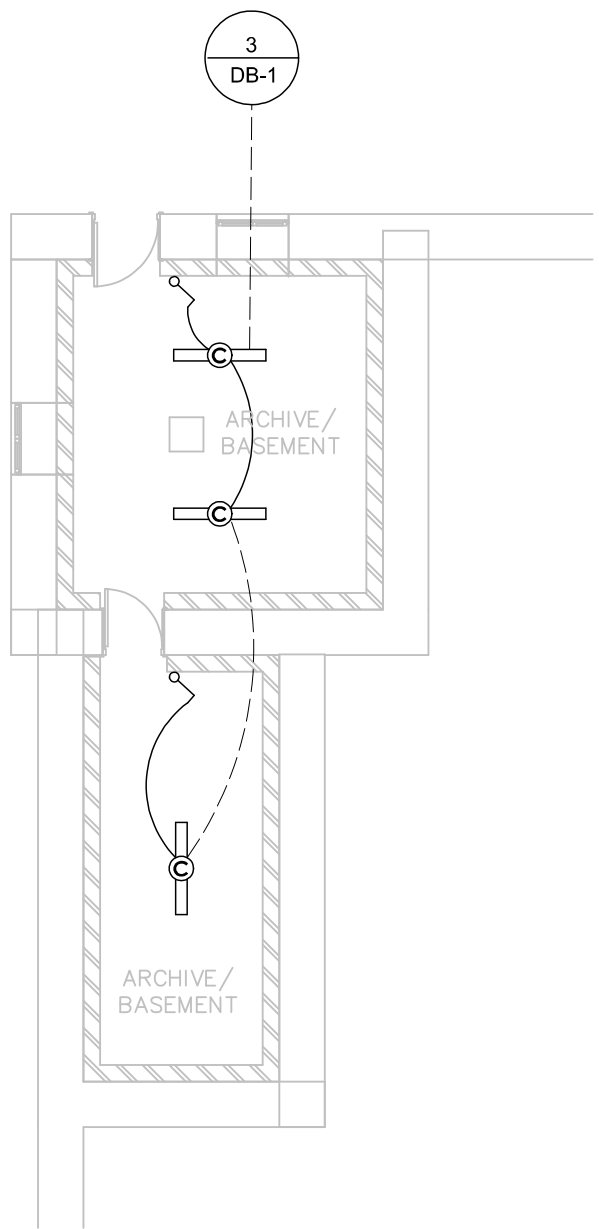

BASEMENT/ ARCHIVE

ALL DIMENSIONS AND LEVELS ARE TO BE VERIFIED ON SITE BY THE CONTRACTOR BEFORE COMMENCING ANY WORK.

A	03/2028	FOR APPROVAL	R.K
NO	DATE	REVISION	INIT.

COPYRIGHT RESERVED

CLIENT

BUSINESS AND INTELLECTUAL PROPERTY AUTHORITY

P.O. Box 185, Windhoek
172 Jan Jonker Road, Auspangplatz
+264 61 299 4400

CONSULTANTS

ARCHITECT

MARLEY TJITJO ARCHITECTS

P.O. Box 96388 Windhoek
No. 4 Prof. Mburumba Kerina Street, Windhoek
+264 61 220 804

QUANTITY SURVEYOR

DAVID NEL QUANTITY SURVEYOR

P.O. Box 40113, Auspangplatz, Windhoek
Unit 403, South Block, Merula Mall,
Jan Jonker Street, Windhoek
+264 61 244 179

CIVIL/STRUCTURAL ENGINEERS

DENCHI consulting engineers

Shop 4, Old Breweries Craft
Complex, Cnr. of Tal & Garden St.
P.O. Box 80352
Windhoek, Namibia
Tel: +264 (61) 22 8183

MECHANICAL/ELECTRICAL ENGINEERS

DENCHI consulting engineers

Shop 4, Old Breweries Craft
Complex, Cnr. of Tal & Garden St.
P.O. Box 80352
Windhoek, Namibia
Tel: +264 (61) 22 8183

PROJECT

PROPOSED NEW BUSINESS AND INTELLECTUAL PROPERTY AUTHORITY (BIPA) HEAD OFFICE

DRAWING TITLE

LIGHTING LAYOUT

DESIGNED

R.K

DRAWN

R.K

APPROVED FOR DENCHI

A.S

DATE OF ISSUE

FEBRUARY 2025

APPROVAL BY CLIENT

FOR CLIENT

DATE

SCALE

1:100

DRAWING NO.

2518-E-01

REVISIONS

A

CADDIE

29

SHEET SIZE

A1

P:\2518 - Proposed BIPA Office Development on Erf 8801 - Windhoek\Drawings\BIPHeadOffice\2518-E-01.dwg